

		Ext	ernal Lighting Schedule				
Reference	Manufacturer	Model	Description	Lamp	Output	Color Temp.	Emergency Lighting
LEP.1	Thorlux Lighting	SB031A2XL	Starbeam - Area distribution - LED streetlight	LED	3225 lm	4000 K	No

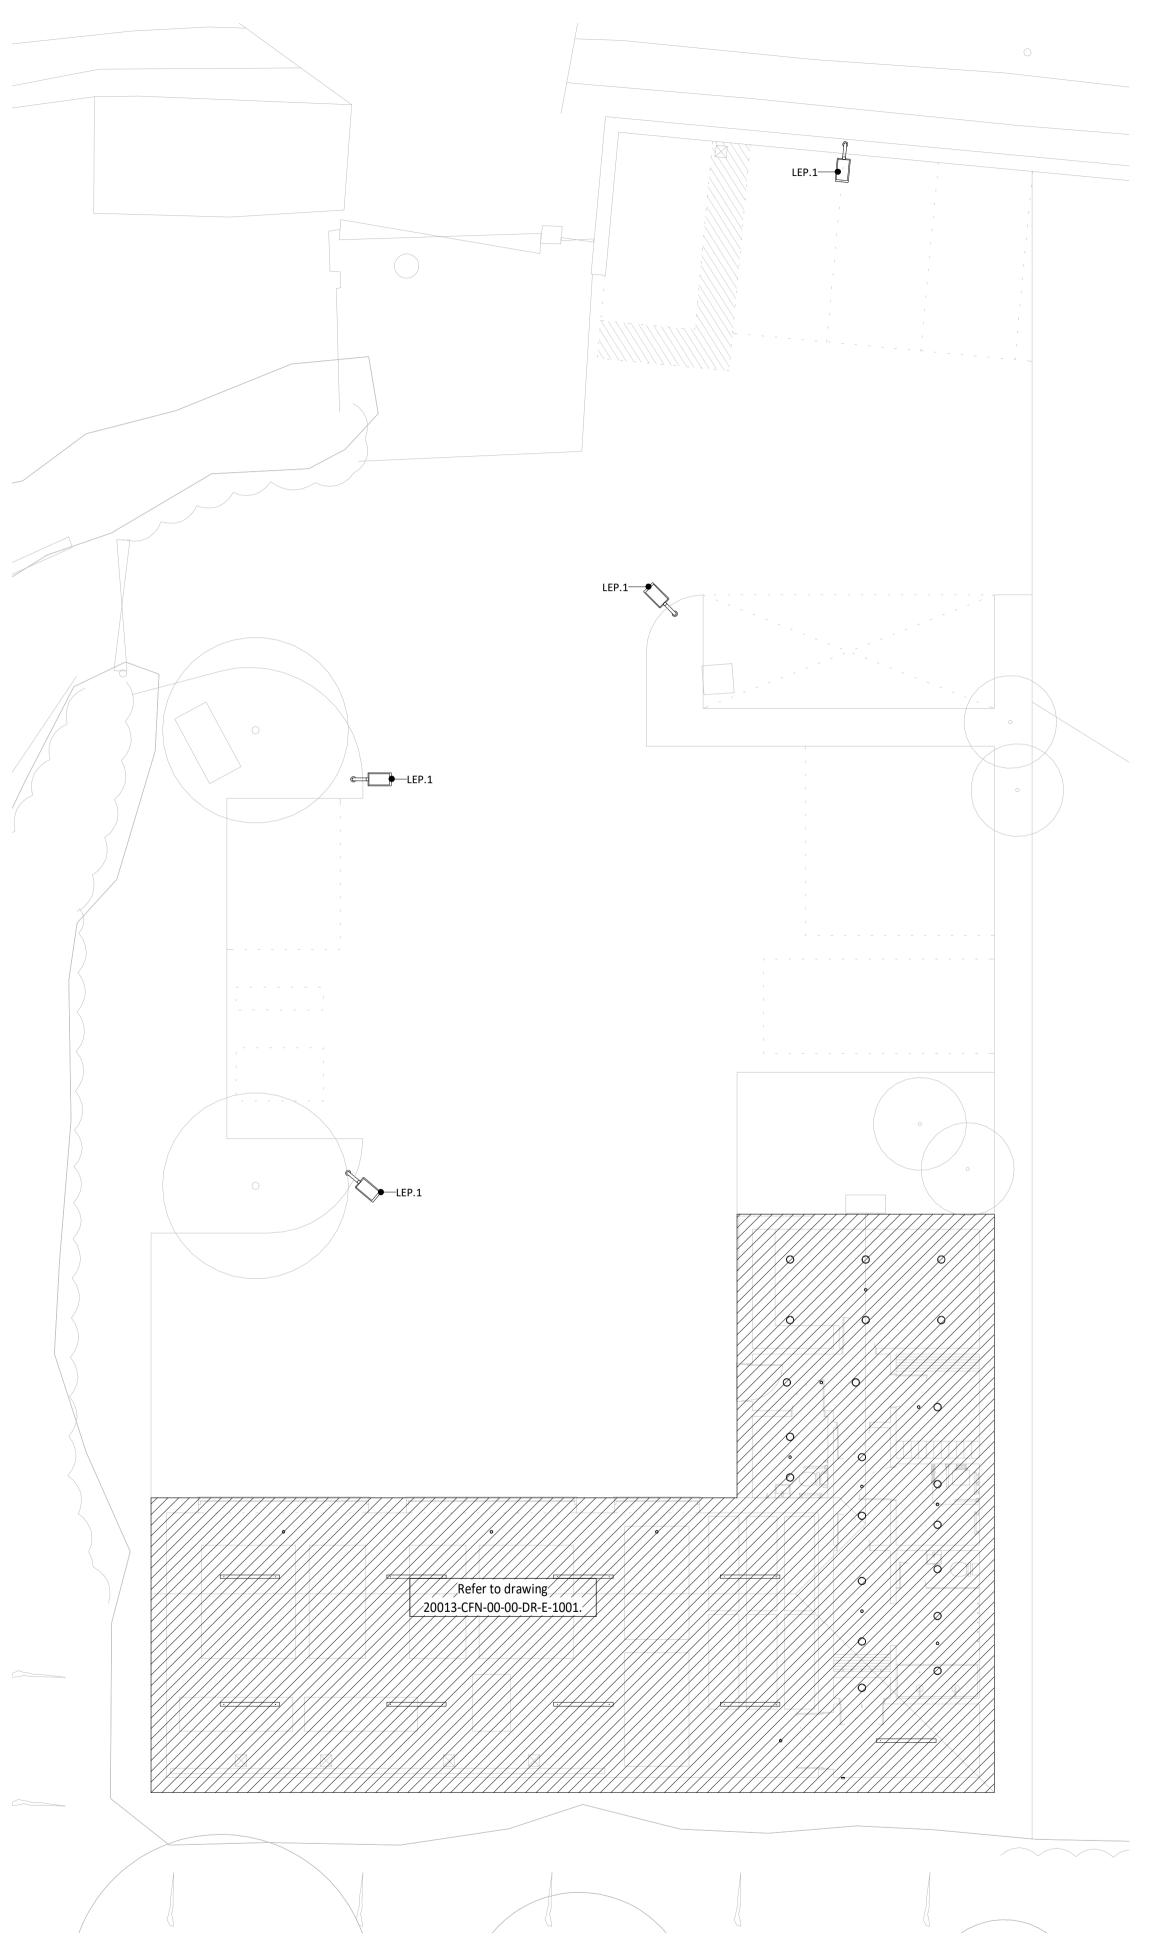

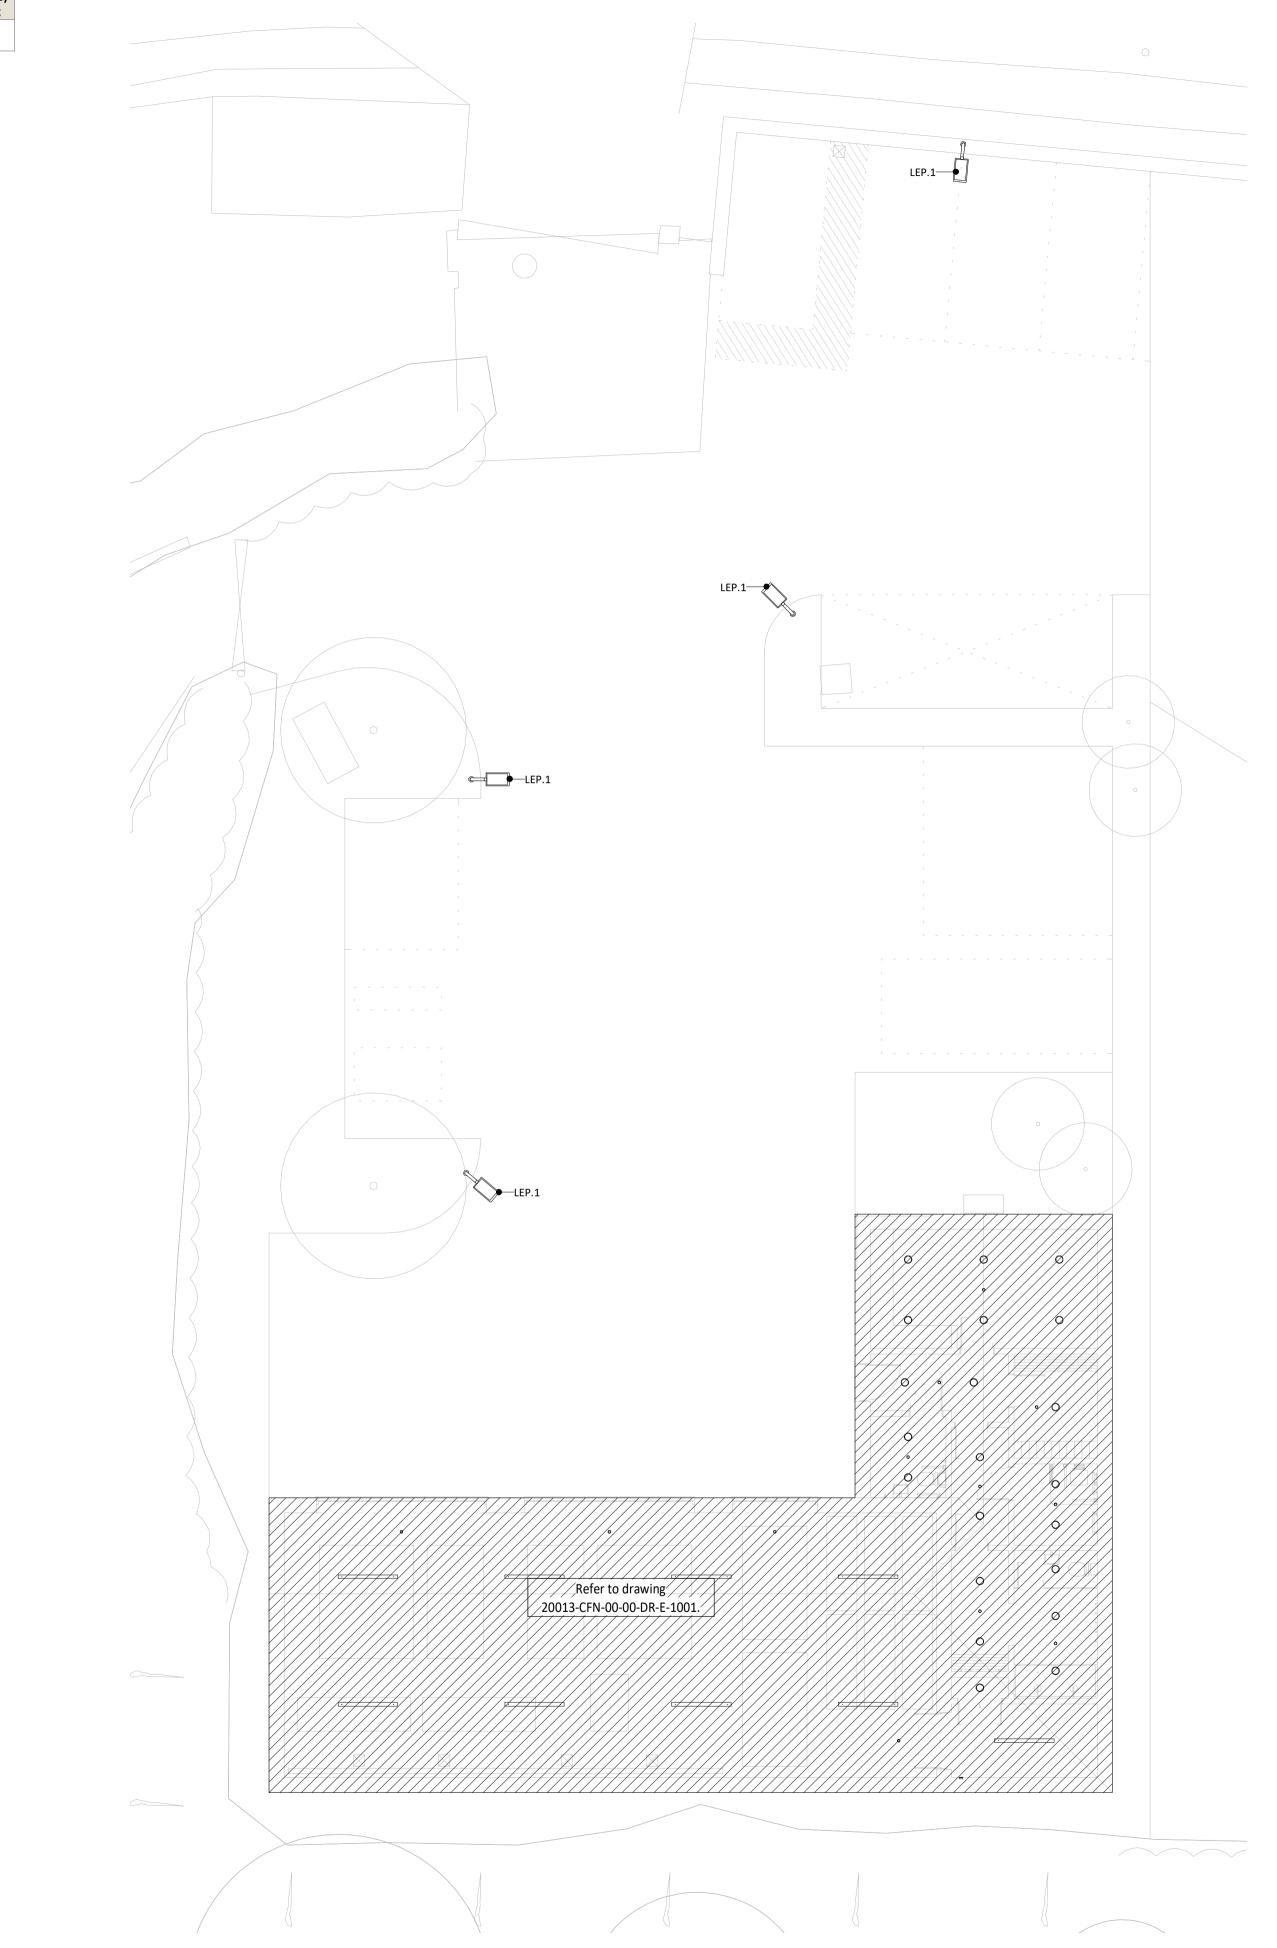

<ul> <li>this drawing is current and fit for use.</li> <li>This drawing is to be read in conjunction with all other relevand drawing issues and specification.</li> <li>All building materials, components and workmanship are to with the appropriate building regulations, British Standards a of practice and the appropriate manufacturers recommendation.</li> <li>For all specialist work see relevant drawings.</li> <li>Any discrepancies, errors or omissions are to be reported to project coordinator for further instructions before commence works.</li> <li>The engineer is not responsible for dimensions, except wher on their drawings. All setting out information, dimensions, except</li> </ul>	<ul> <li>Refer to the most current Document Issue Register to ensure this drawing is current and fit for use.</li> <li>This drawing is to be read in conjunction with all other releval drawing issues and specification.</li> <li>All building materials, components and workmanship are to cwith the appropriate building regulations, British Standards a of practice and the appropriate manufacturers recommendate.</li> <li>For all specialist work see relevant drawings.</li> <li>Any discrepancies, errors or omissions are to be reported to project coordinator for further instructions before commence works.</li> <li>The engineer is not responsible for dimensions, except where on their drawings. All setting out information, dimensions, et be calculated from the architect's drawings.</li> </ul>	Notes:					
<ul> <li>this drawing is current and fit for use.</li> <li>This drawing is to be read in conjunction with all other relevand drawing issues and specification.</li> <li>All building materials, components and workmanship are to with the appropriate building regulations, British Standards a of practice and the appropriate manufacturers recommendate.</li> <li>For all specialist work see relevant drawings.</li> <li>Any discrepancies, errors or omissions are to be reported to project coordinator for further instructions before commence works.</li> <li>The engineer is not responsible for dimensions, except wher on their drawings. All setting out information, dimensioned of walls see architect's drawings.</li> </ul>	<ul> <li>this drawing is current and fit for use.</li> <li>This drawing is to be read in conjunction with all other releval drawing issues and specification.</li> <li>All building materials, components and workmanship are to convict the appropriate building regulations, British Standards a of practice and the appropriate manufacturers recommendate.</li> <li>For all specialist work see relevant drawings.</li> <li>Any discrepancies, errors or omissions are to be reported to project coordinator for further instructions before commence works.</li> <li>The engineer is not responsible for dimensions, except where on their drawings. All setting out information, dimensions, et be calculated from the architect's drawings.</li> <li>Scale 1:100</li> </ul>	• Do no	t scale this	drawing.			
<ul> <li>drawing issues and specification.</li> <li>All building materials, components and workmanship are to with the appropriate building regulations, British Standards a of practice and the appropriate manufacturers recommendate.</li> <li>For all specialist work see relevant drawings.</li> <li>Any discrepancies, errors or omissions are to be reported to project coordinator for further instructions before commence works.</li> <li>The engineer is not responsible for dimensions, except wher on their drawings. All setting out information, dimensions, e be calculated from the architect's drawings. For dimensioned of walls see architect's drawings.</li> </ul>	<ul> <li>drawing issues and specification.</li> <li>All building materials, components and workmanship are to of with the appropriate building regulations, British Standards a of practice and the appropriate manufacturers recommendate.</li> <li>For all specialist work see relevant drawings.</li> <li>Any discrepancies, errors or omissions are to be reported to project coordinator for further instructions before commence works.</li> <li>The engineer is not responsible for dimensions, except where on their drawings. All setting out information, dimensions, errors of walls see architect's drawings.</li> </ul>					ssue Regis	ter to ensure
<ul> <li>with the appropriate building regulations, British Standards a of practice and the appropriate manufacturers recommendate.</li> <li>For all specialist work see relevant drawings.</li> <li>Any discrepancies, errors or omissions are to be reported to project coordinator for further instructions before commence works.</li> <li>The engineer is not responsible for dimensions, except wher on their drawings. All setting out information, dimensions, e be calculated from the architect's drawings. For dimensioned of walls see architect's drawings.</li> </ul>	<ul> <li>with the appropriate building regulations, British Standards as of practice and the appropriate manufacturers recommendate.</li> <li>For all specialist work see relevant drawings.</li> <li>Any discrepancies, errors or omissions are to be reported to project coordinator for further instructions before commence works.</li> <li>The engineer is not responsible for dimensions, except where on their drawings. All setting out information, dimensions, e be calculated from the architect's drawings. For dimensioned of walls see architect's drawings.</li> </ul>					on with all	other releva
<ul> <li>Any discrepancies, errors or omissions are to be reported to project coordinator for further instructions before commence works.</li> <li>The engineer is not responsible for dimensions, except wher on their drawings. All setting out information, dimensions, e be calculated from the architect's drawings. For dimensioned of walls see architect's drawings.</li> </ul>	<ul> <li>Any discrepancies, errors or omissions are to be reported to project coordinator for further instructions before commence works.</li> <li>The engineer is not responsible for dimensions, except where on their drawings. All setting out information, dimensions, e be calculated from the architect's drawings. For dimensioned of walls see architect's drawings.</li> </ul>	with th	ne appropr	iate building	regulati	ons, British	Standards a
<ul> <li>project coordinator for further instructions before commence works.</li> <li>The engineer is not responsible for dimensions, except wher on their drawings. All setting out information, dimensions, e be calculated from the architect's drawings. For dimensioned of walls see architect's drawings.</li> <li>Scale 1:100</li> </ul>	<ul> <li>project coordinator for further instructions before commence works.</li> <li>The engineer is not responsible for dimensions, except wher on their drawings. All setting out information, dimensions, e be calculated from the architect's drawings. For dimensioned of walls see architect's drawings.</li> <li>Scale 1:100</li> </ul>	• For all	specialist	work see rele	evant dra	awings.	
on their drawings. All setting out information, dimensions, e be calculated from the architect's drawings. For dimensioned of walls see architect's drawings.	on their drawings. All setting out information, dimensions, e be calculated from the architect's drawings. For dimensioned of walls see architect's drawings.	projec	t coordinat				
		on the be cale	ir drawings culated fro	s. All setting m the archite	out info ct's drav	rmation, d	imensions, e
1m 3m 5m	1m 3m 5m						
		Scal	e 1:100				
		Scal		3m		5m	
		Scal		3m		5m	
12/01/2021 S3-P3 Preliminary Issue 27/11/2020 S3-P2 Preliminary Issue S2-P1 Preliminary Issue 20/11/2020 Status Description Date Client Tunbridge Wells Borough Council Project Benhall Mill Cemetery Depot Drawing External Lighting Layout

## PRELIMINARY

Scale @ A1 1:100



File Name 20013-CFN-00-XX-DR-E-1000