


Proposed Front Elevation 1-100@A3

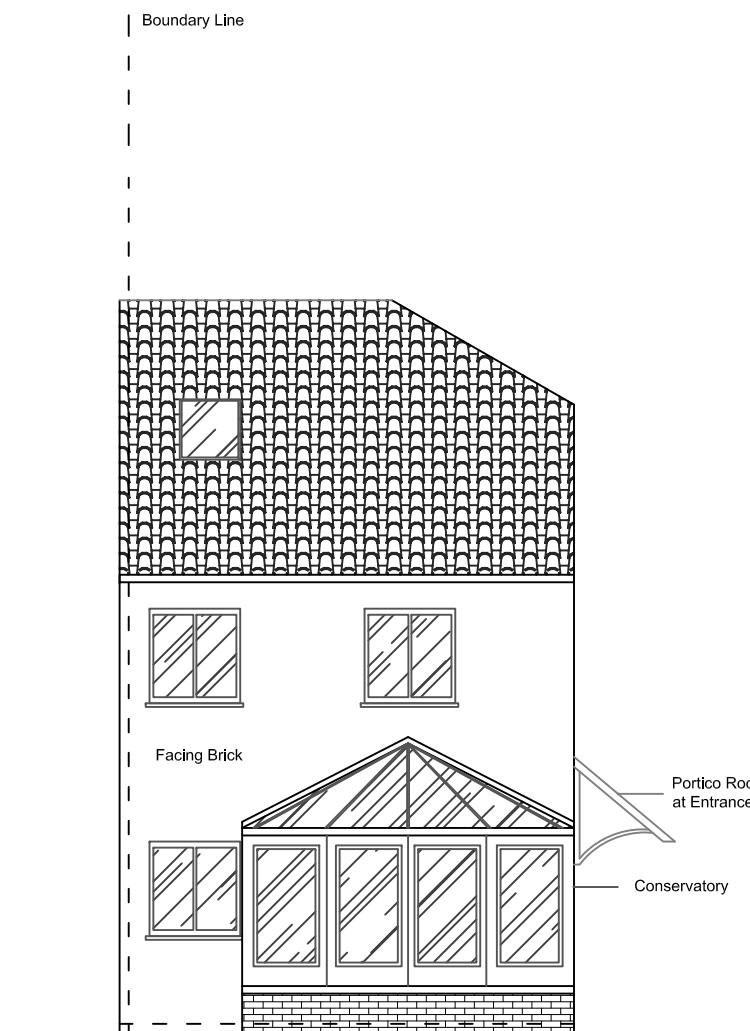

Proposed Back Elevation 1-100@A3

 SD	Smoke detector & fire alarm	 IP	Indicator Panel	 FD30	30 Min Rated Fire Door		Existing Walls	 	Spot Lights
 HD	Heat Detector	 CP	Manual Call Point	 FD60	60 Min Rated Fire Door		Brick Walls	 	Track Lights
 H2O	H2O Extinguisher	 EL	Emergency lighting	 Aircon	Air-conditioning		New Stud Walls	 	Concealed strip lights
 CO2	CO2 Extinguisher	 FB	Fire Blanket	 Ventilation	Ventilation		Shelving	 	Pendant lights

				
CLIENT		DRAWING NO.	DESIGNED BY FELIX	SCALE 1 : 100
PROJECT ADDRESS	60 Lower Green Gardens KT4 7NX	P-05	APPROVED BY	DATE 5/3/22