


## **Ground Floor Electrical Plan**

Plot 03 Scale 1:50

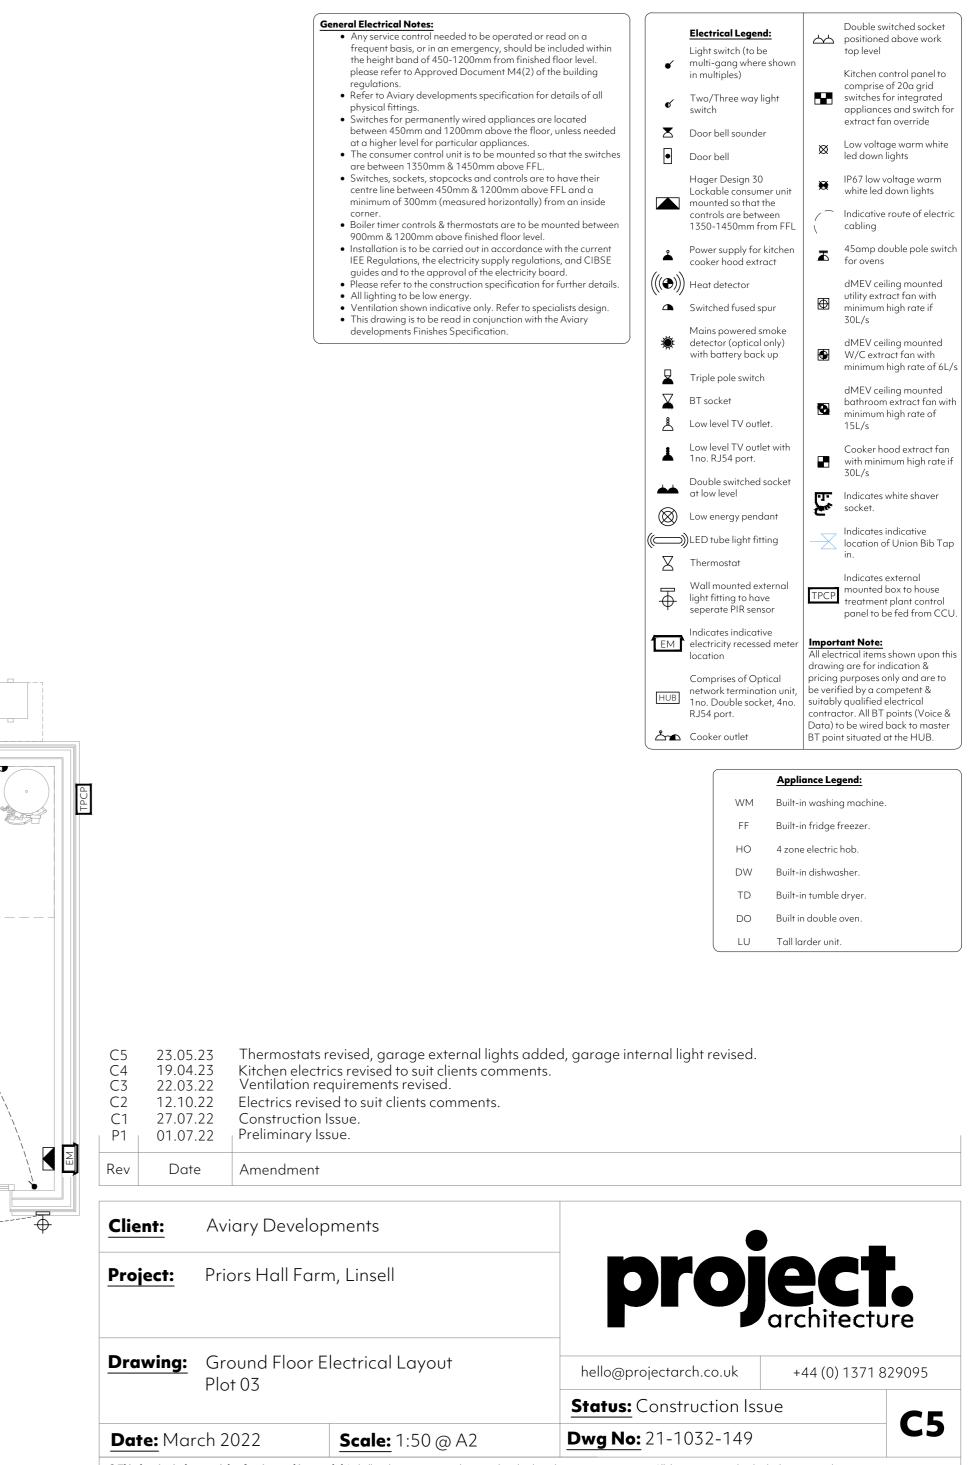

<sup>©</sup> This drawing is the copyright of project.architecture ltd. It shall not be in any way used or reproduced without their prior written consent. All dimensions are to be checked on site or in the workshop prior to commencing any work. do not scale from this drawing. Work only to figured dimensions. Any perceived discrepancies are to be reported to the architect at the earliest opportunity.