
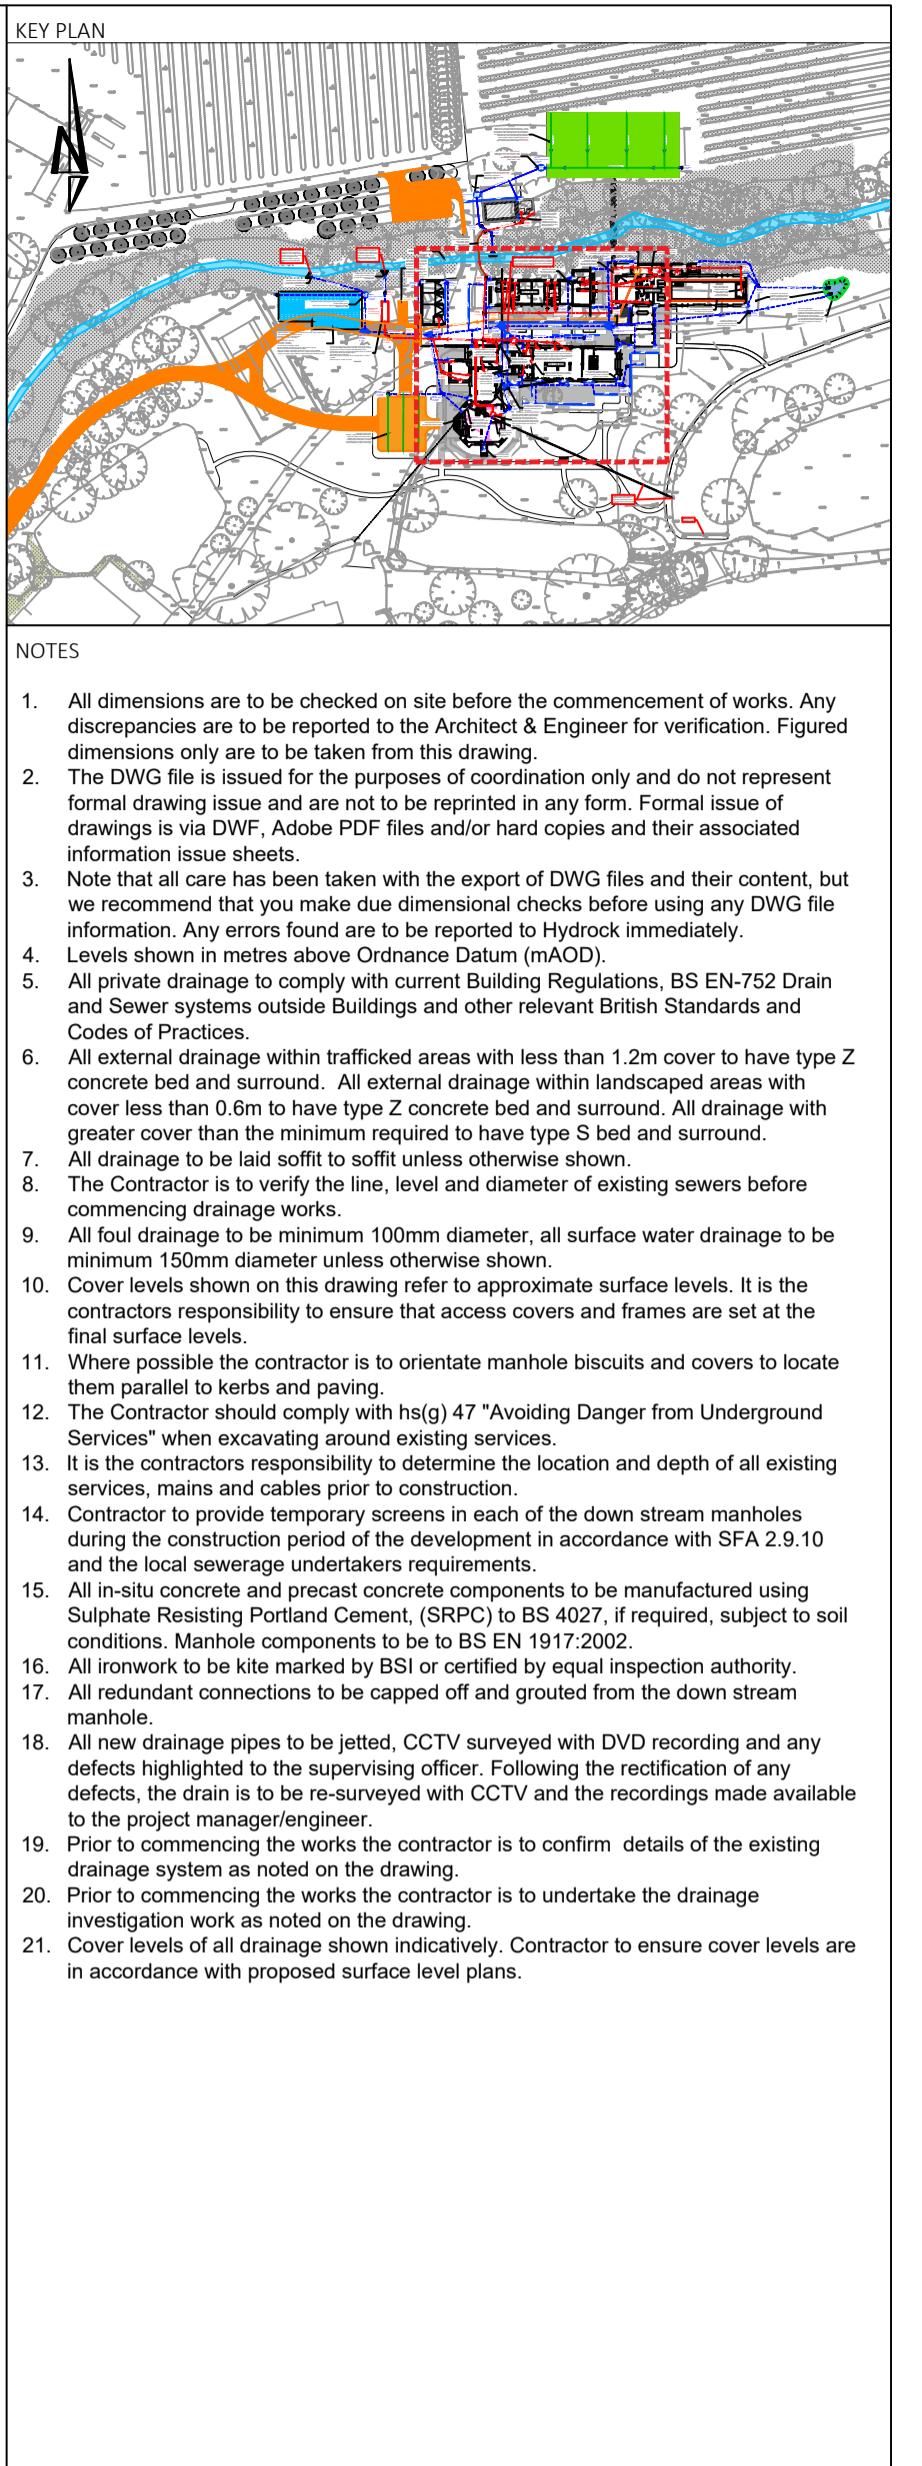


KEY:

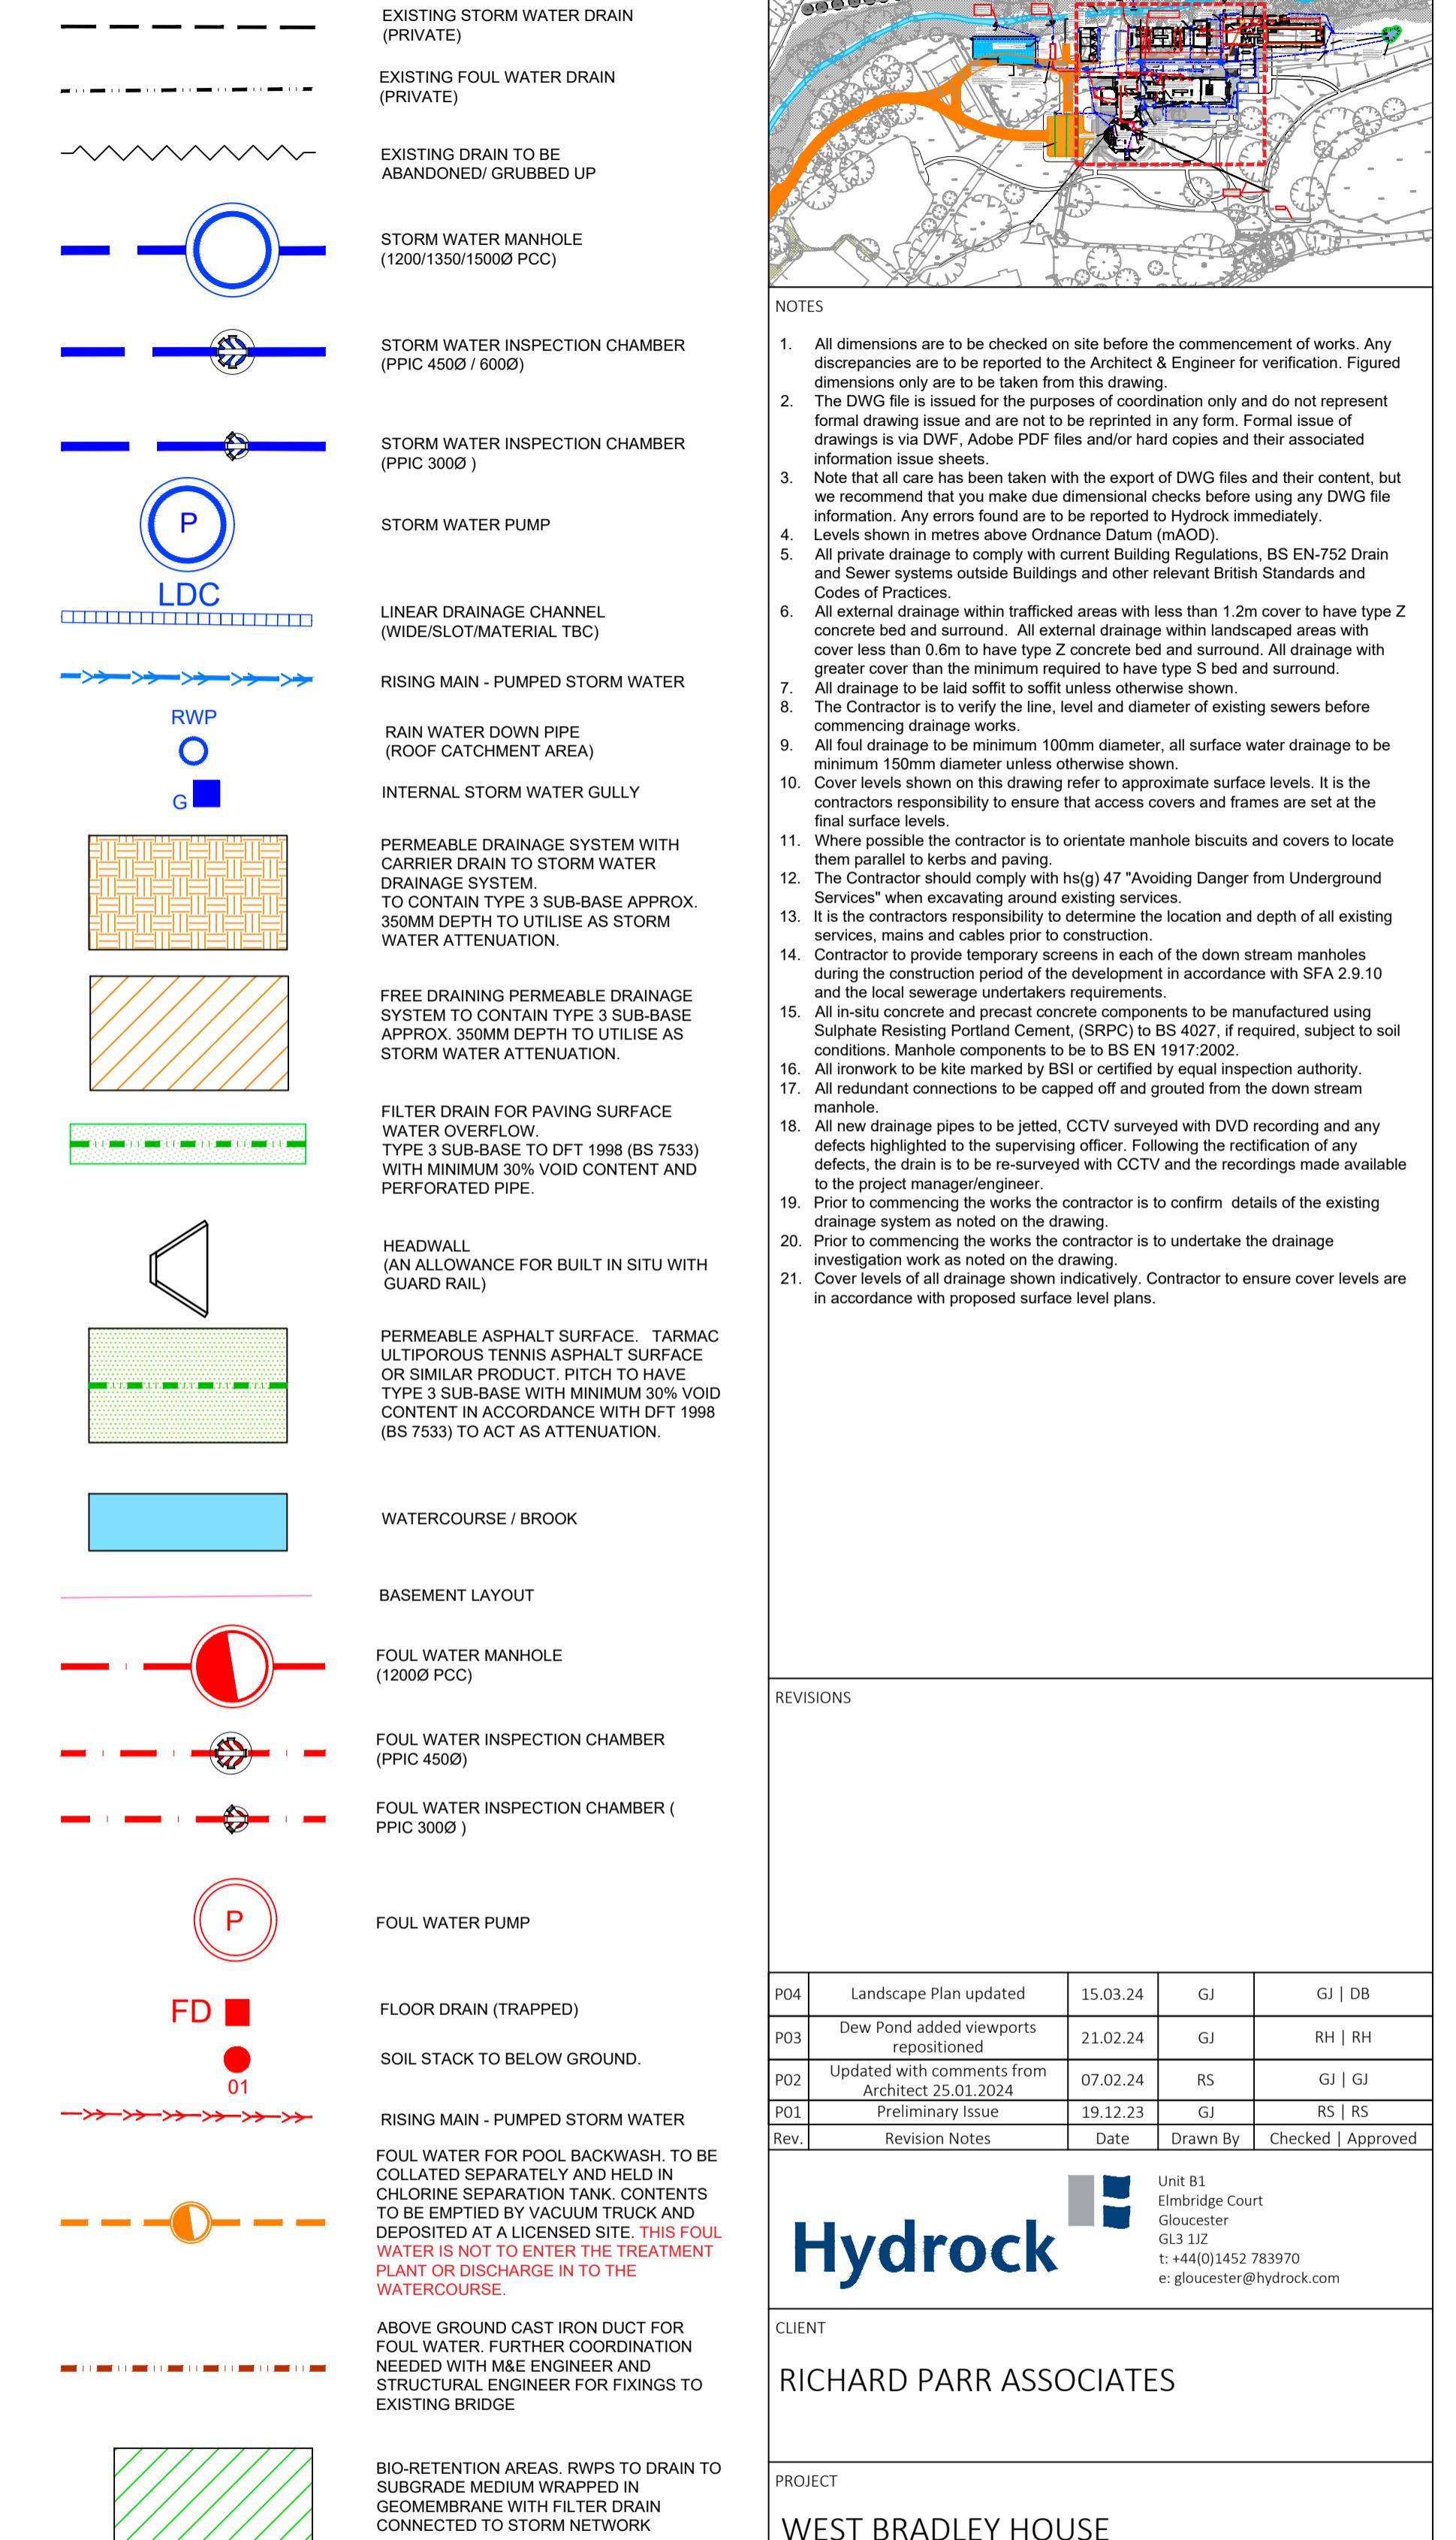

P04	Landscape Plan updated	15.03.24	GJ	GJ DB
P03	Dew Pond added viewports repositioned	21.02.24	GJ	RH RH
P02	Updated with comments from Architect 25.01.2024	07.02.24	RS	GJ GJ
P01	Preliminary Issue	19.12.23	GJ	RS RS
Rev.	Revision Notes	Date	Drawn By	Checked Approved

Unit B1
Elmbridge Court
Glastonbury
GL1 1TZ
t: +44(0)1452 783970
e: gloucester@hydrock.com

CLIENT

RICHARD PARR ASSOCIATES

PROJECT

WEST BRADLEY HOUSE
GLASTONBURY

TITLE
DRAINAGE LAYOUT
SHEET 2

HYDROCK PROJECT NO.	SCALE @ A1
28421	1:100
STATUS DESCRIPTION	
SUITABLE FOR INFORMATION	S2
DRAWING NO.	REVISION
28421-HYD-XX-XX-DR-C-7002	P04